


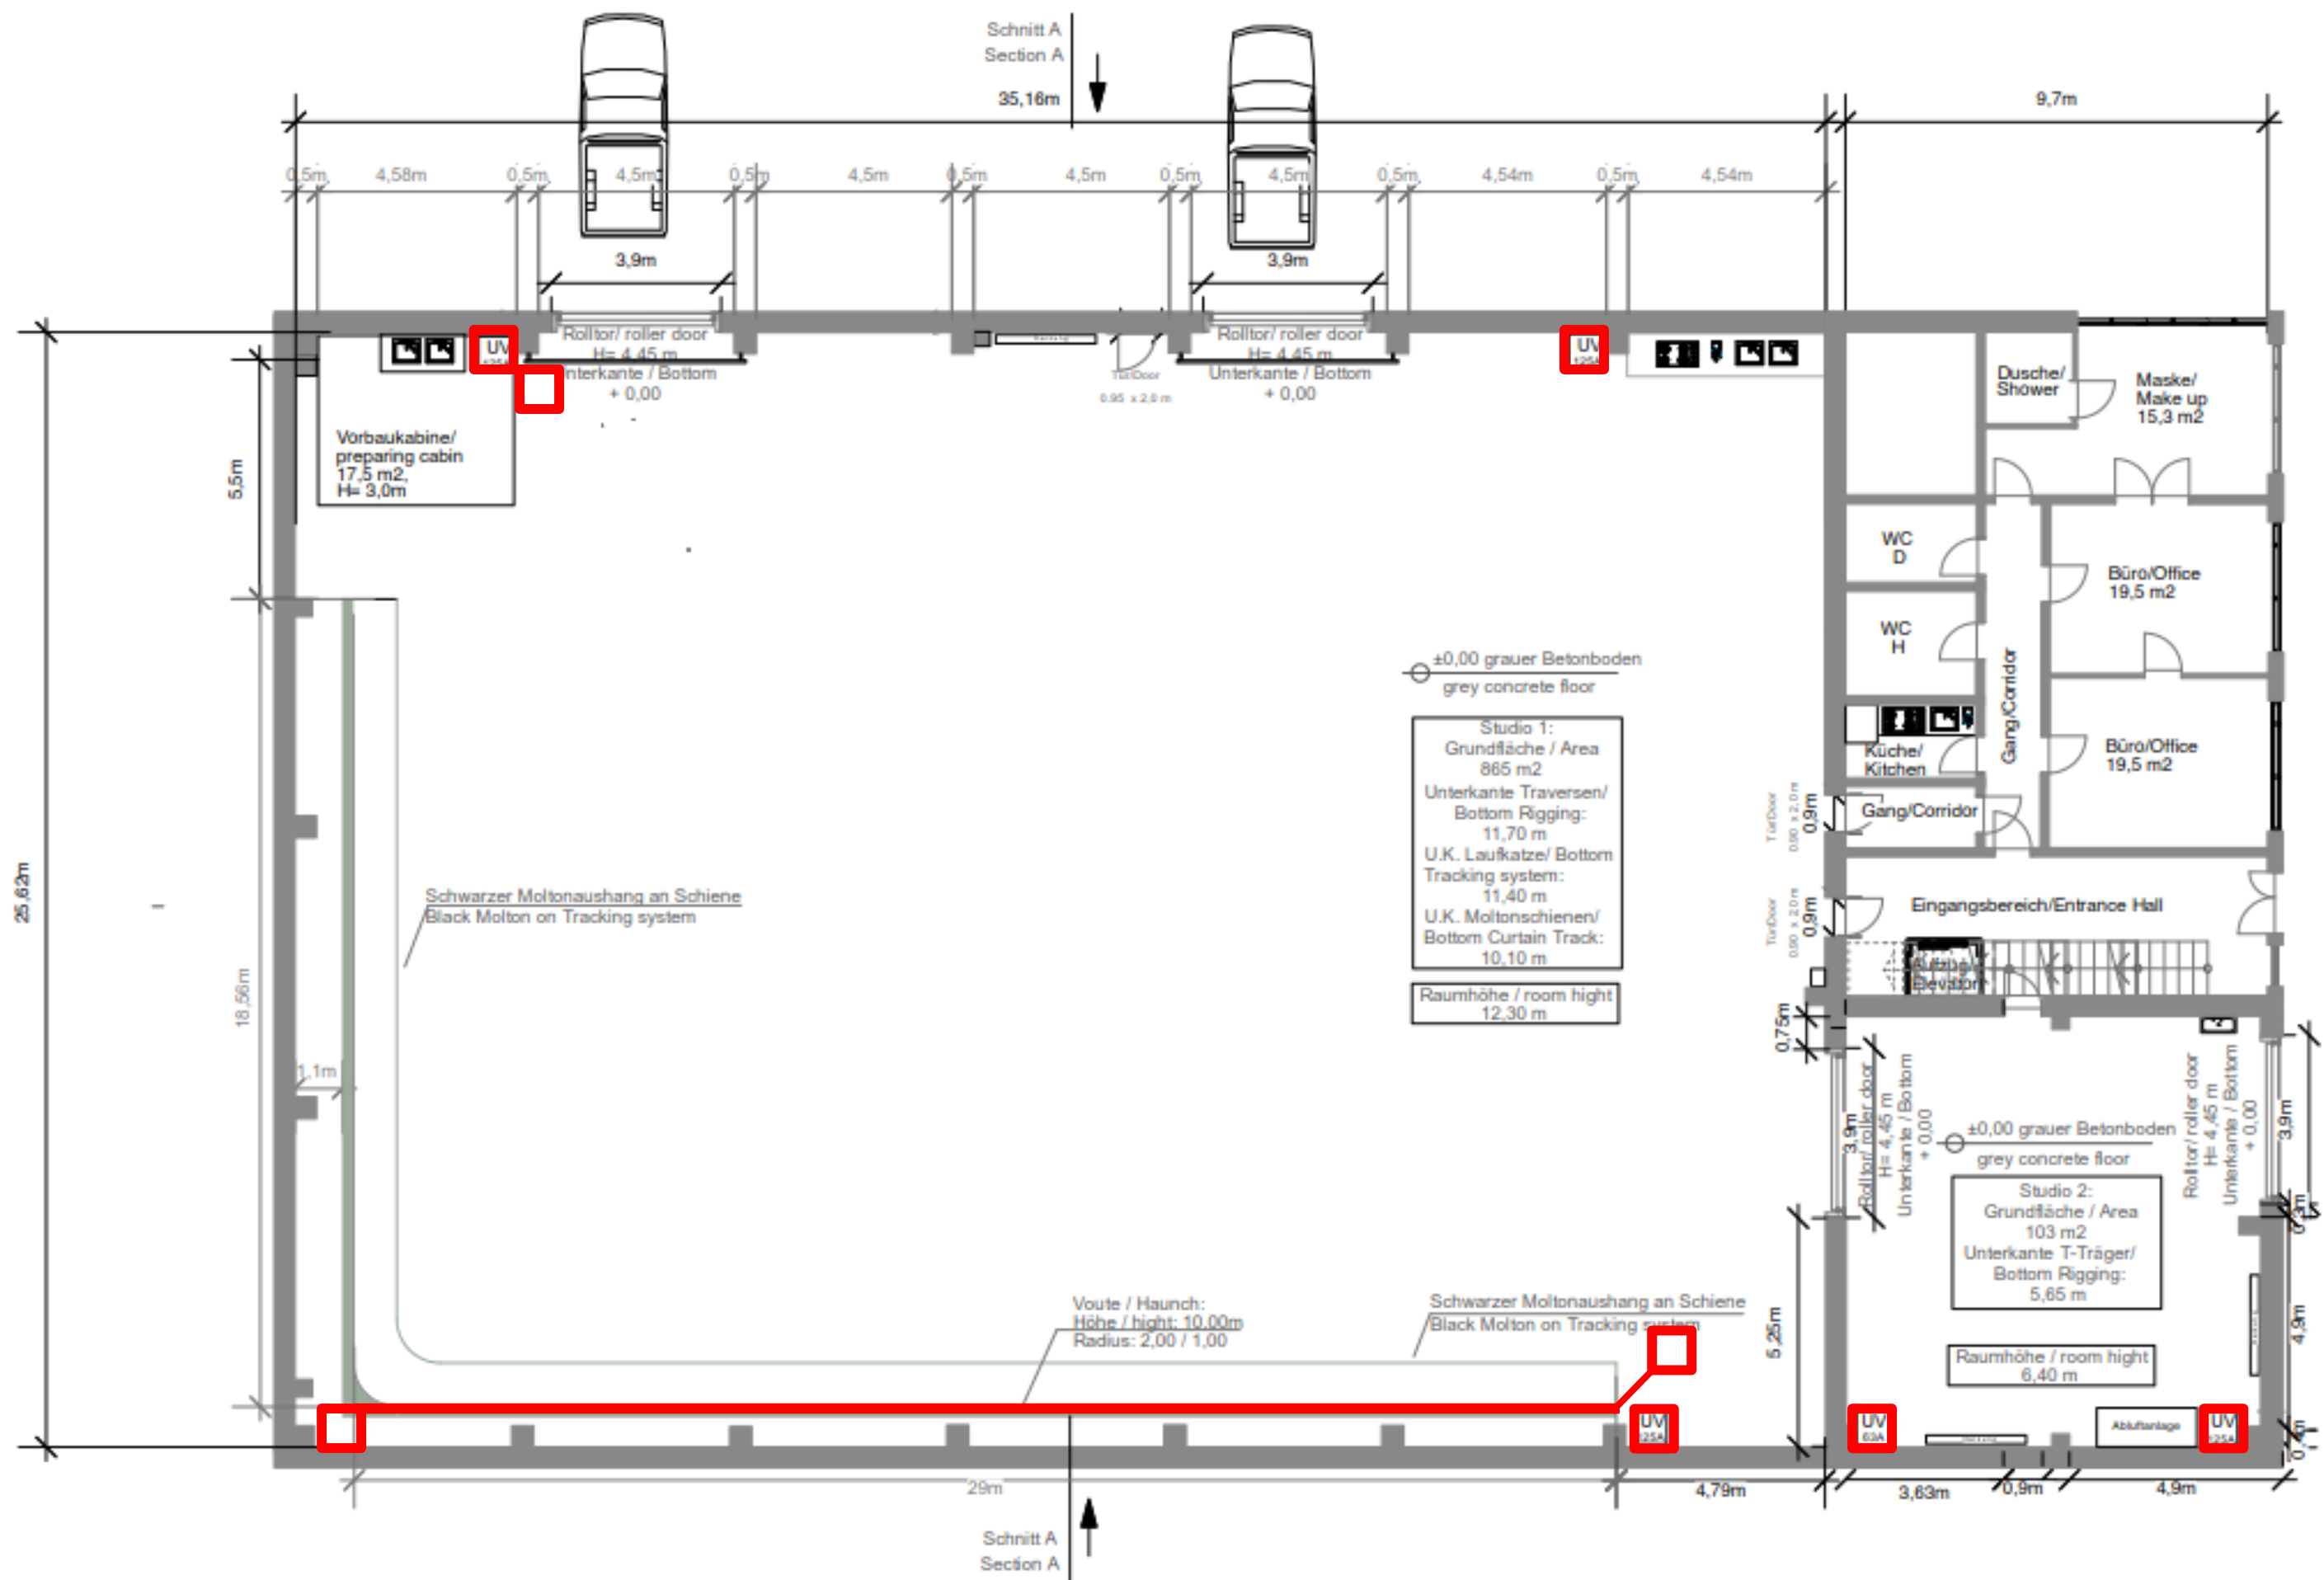

EG. / Ground Floor

□ 125A Steckdosen

STUDIO 1+2 HAMBURG

Grundriss / Floor Plan

Scale: 1:200 @ A4