


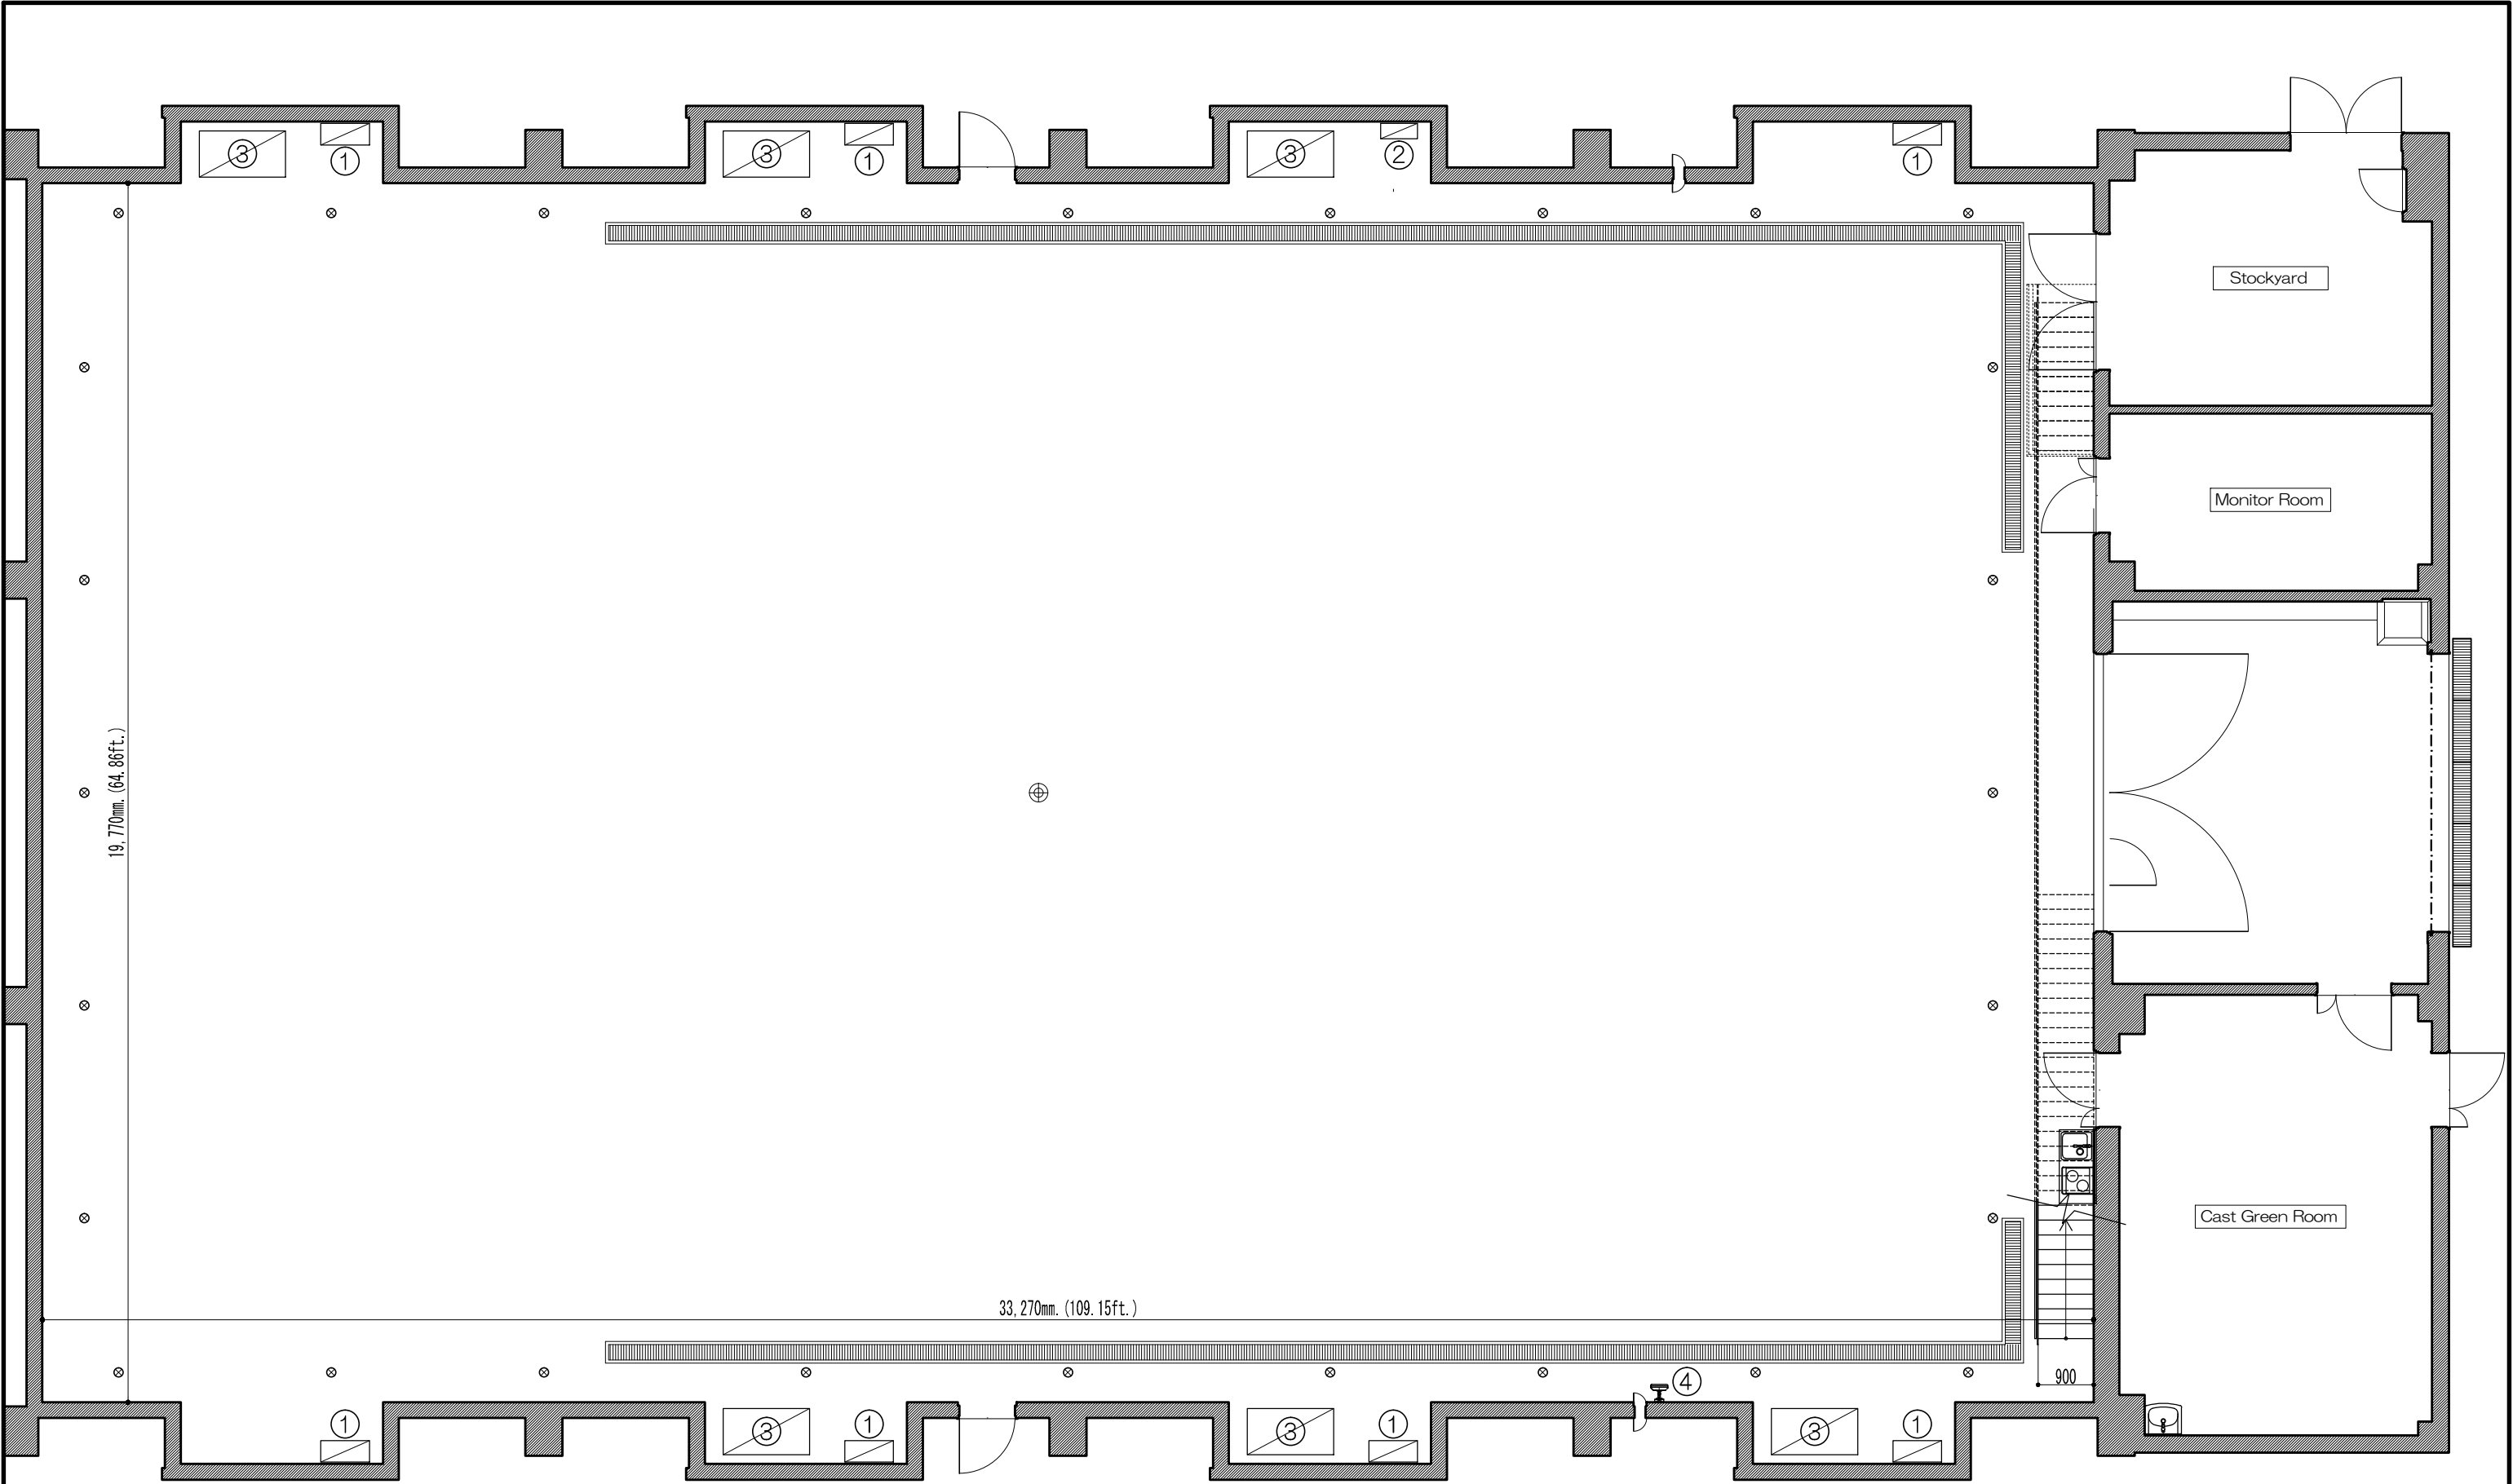

PAPER SIZE A3

GROUND LEVEL FLOOR PLAN (P-2/5)

NOTICE	①	Electrical supply point	⊗	Hooks for wire action	TOHO STUDIOS 東宝スタジオ 1-4-1SEIJO SETAGAYA-KU TOKYO 東宝映画グループ	No. 10 STAGE	SIZE 657.7m ²	TITLE	DESIGNER
	②	Mains Power three-phase system(200V/60A)					SCALE 1:100	PRODUCTION	DATE
	③	Air conditioner							
	④	Controller of Hoists							